


PLANO DE INSTALACIONES ELECTRICAS

ESTACION DE TULUA

PLANTA BAJA

FERROCARRIL DEL PACIFICO

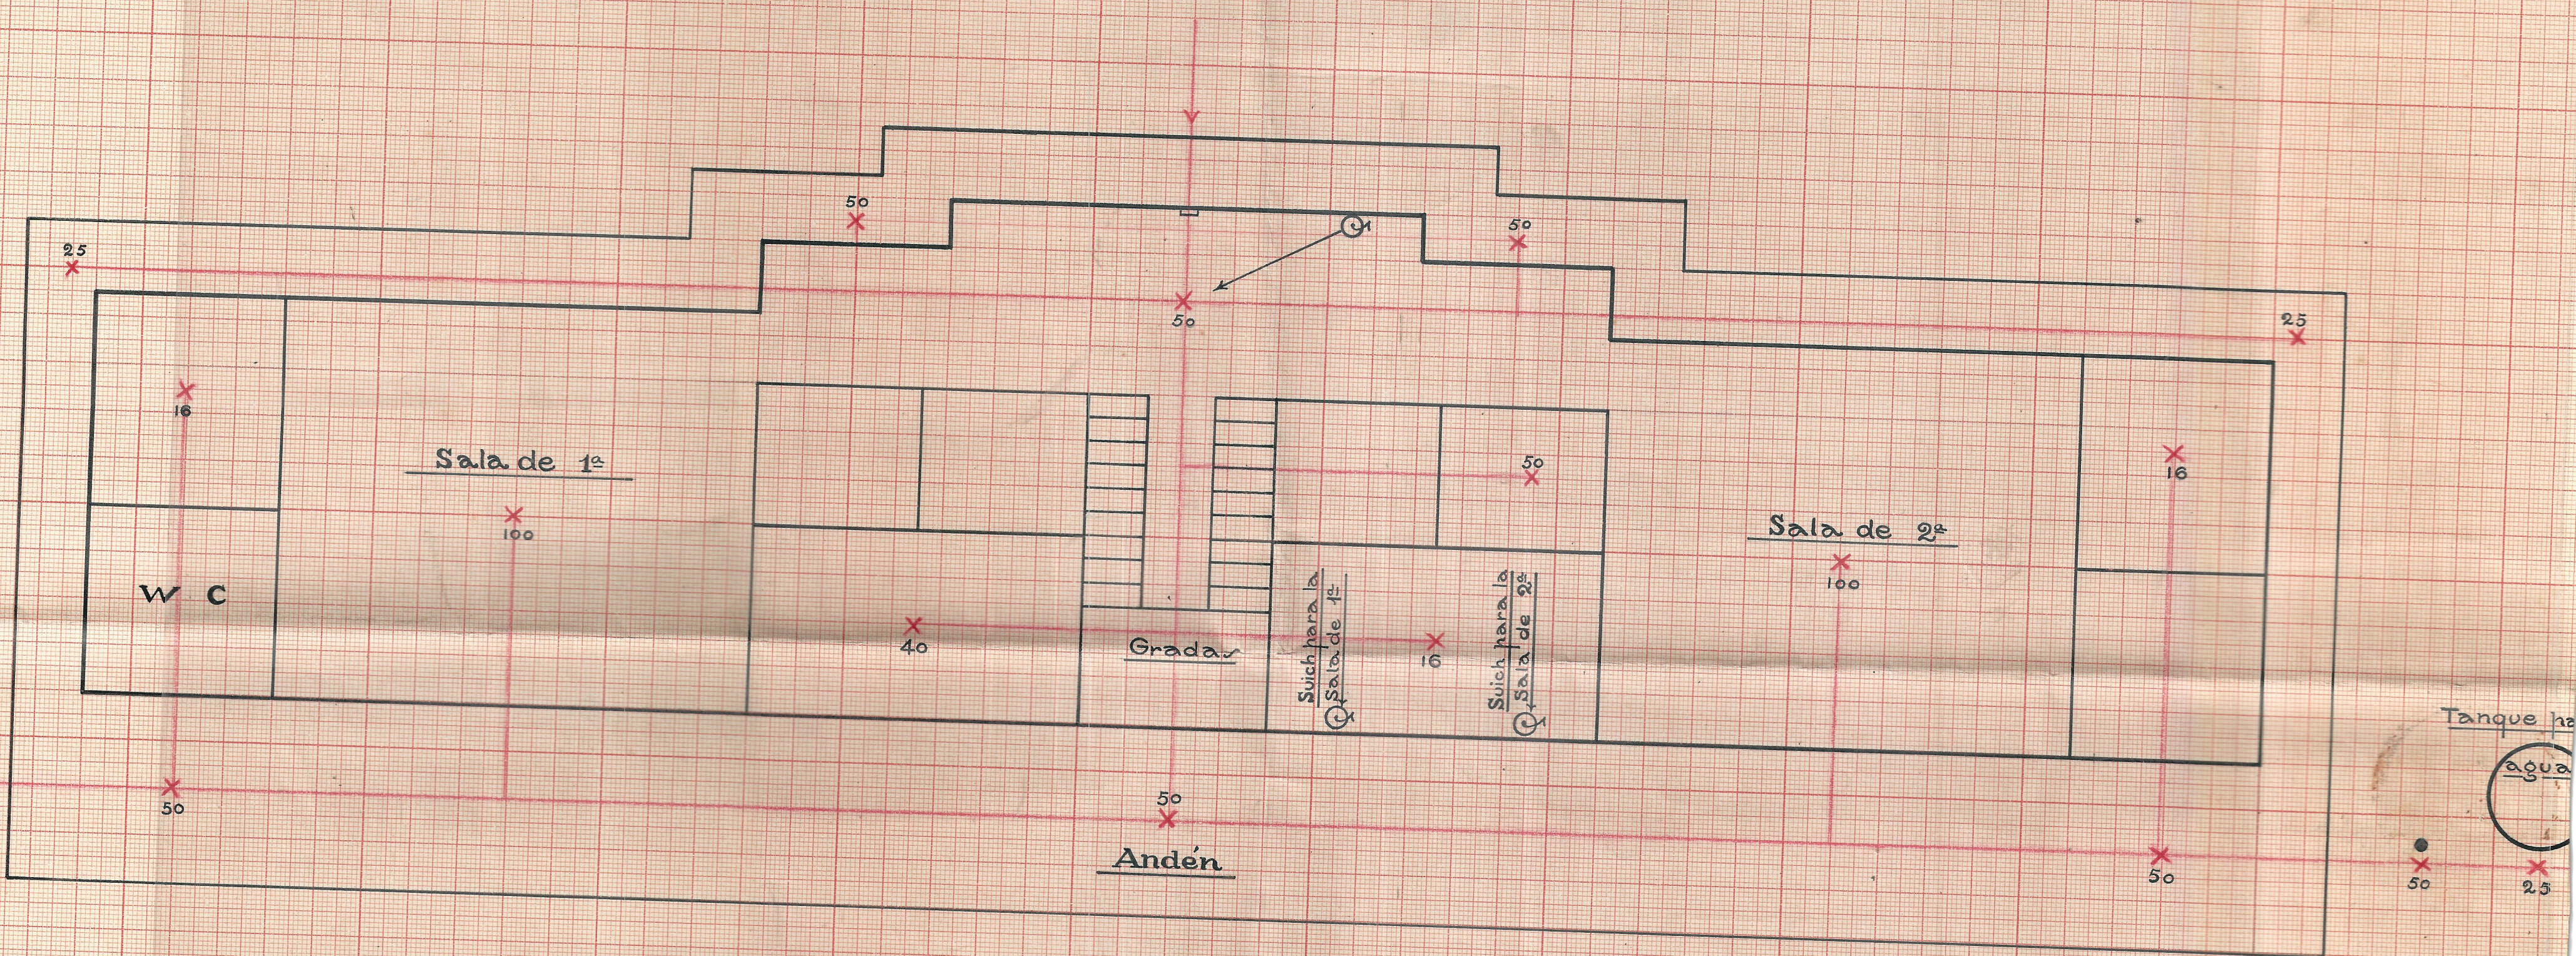

Explicaciones

Escala 1:100

X	Bombillo	2 de	100 watts	=	200 watts
X	"	8 "	50 "	=	400 "
X	"	4 "	25 "	=	100 "
X	"	3 "	16 "	=	48 "
X	"	1 "	40 "	=	40 "
		18	con	=	788 watts
⊙	Switches - 3 -				

Macbarr